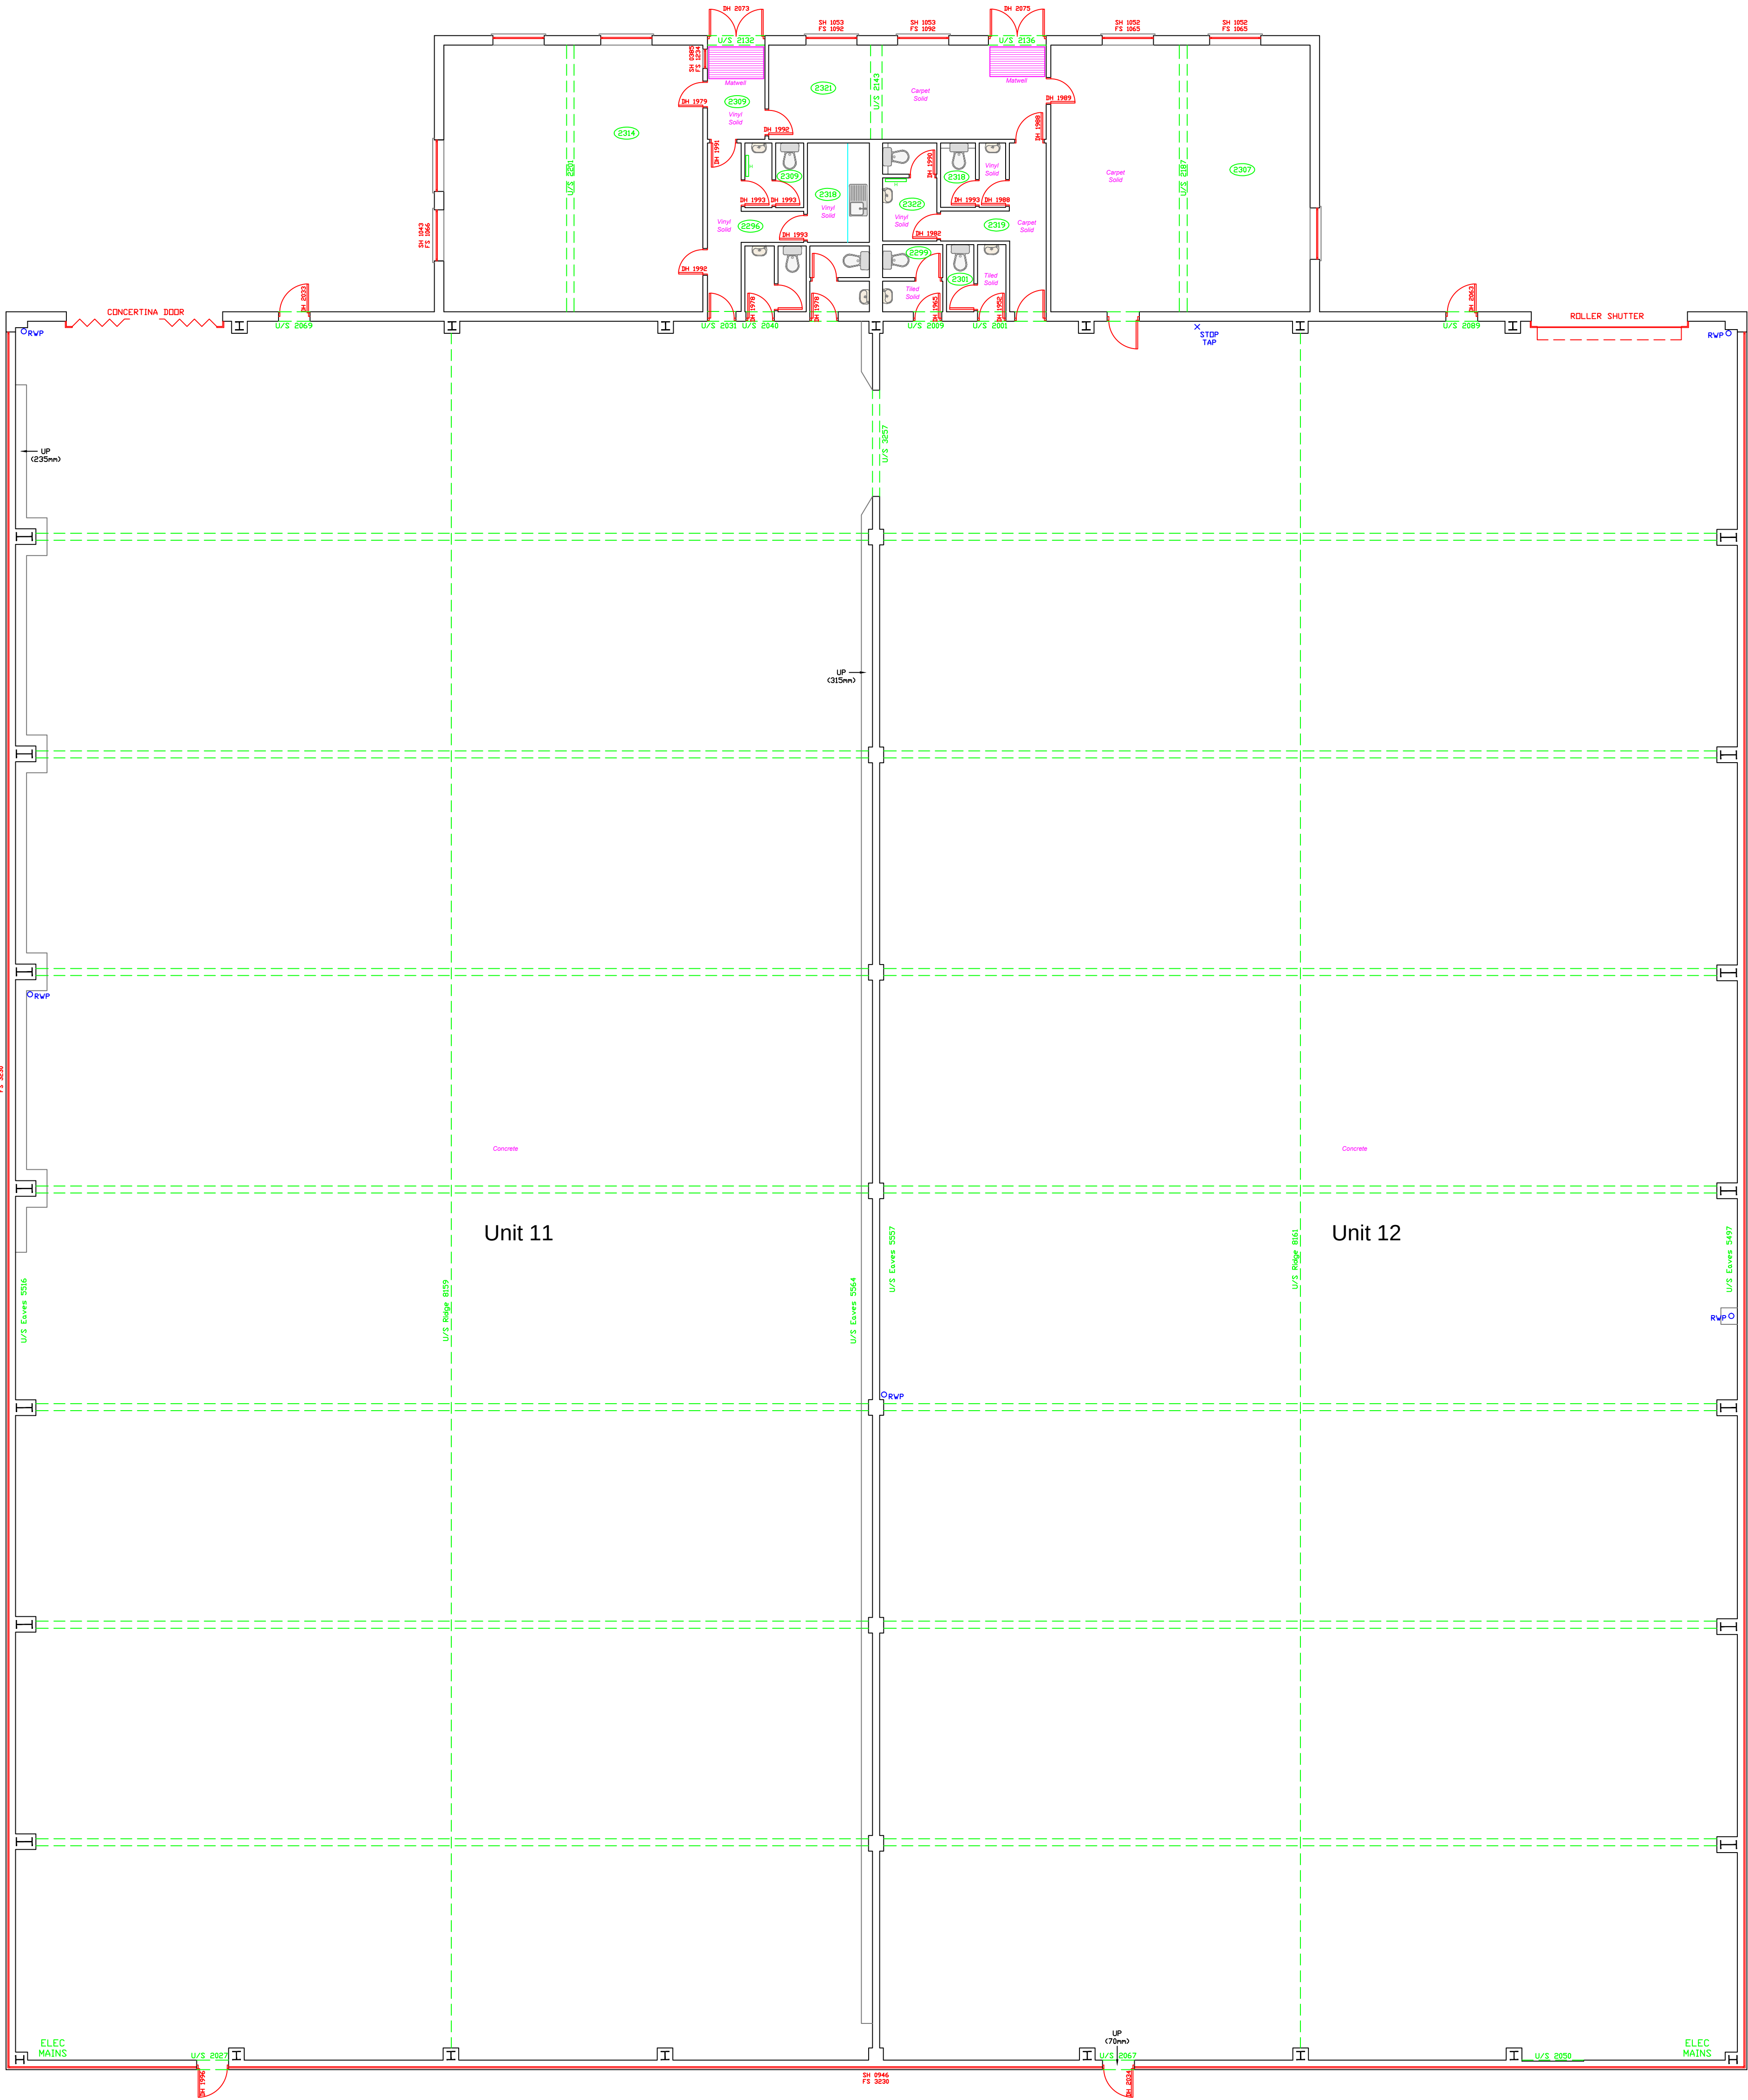
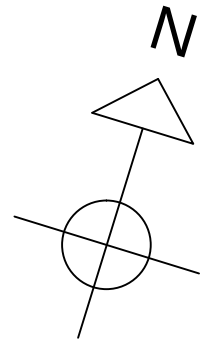


Notes and Limitations:

Where dimensions are not given, drawings must not be scaled and the matter referred to Baya Building Consultancy LTD.

In the event of any dimensional conflict between Baya Building Consultancy's drawings, the matter must be referred to Baya Building Consultancy LTD for clarification.

The recipient of any drawing produced by Baya Building Consultancy LTD must also refer to any separate Specification or documentation in conjunction with this drawing and project particulars.

Symbol and Linetype Key:

BTM - Temporary bench mark	elec - Electricity mains
ff - Finished floor level	elmt - Electricity meter
tl - Threshold level	g/mtr - Gas meter
fh - Floor to head height	ffr - First floor rest
sh - Sill to head height	bt - Telecoms point
fr - Floor to fill height	s/s - Single power socket
u/s - Underside height	ds/s - Double power socket
ah - Arch head height	ls - Light switch
ap - Arch springing point height	c/p - Cooker point
rad - Radiator	lf - Light fitting
htr - Heater	fl - Fluorescent light fitting
hw - Hot water tank	htr - Intruder alarm sensor
wt - Toilet	fsr - Fire alarm sensor
wb - Wash basin	hazp - Burglar alarm control panel
shr - Shower	facp - Fire alarm control panel
bat - Bath	cp - Control panel
ur - Urinal	w/m - Water meter
hd - Hand dryer	sets - Water stop tap
wp - Waste pipe	ic - Inspection chamber
vp - Vent pipe	m/c - Manhole cover
rwp - Rainwater pipe	cl - Cover level
wf - Water fountain	il - Invert level
g - Gully	Ø - Pipe diameter
c - Concrete	conc - Concrete
h - Roof hatch	bk - Brick
vac - Suspended ceiling	qt - Quarry tiles
h - Room height	v - Vinyl flooring
carp - Carpet flooring	carp - Carpet flooring
b/st - Brick setts	b/st - Brick setts
fb - Floorboards	

Annotation Key:

BTM - Temporary bench mark	elec - Electricity mains
ff - Finished floor level	elmt - Electricity meter
tl - Threshold level	g/mtr - Gas meter
fh - Floor to head height	ffr - First floor rest
sh - Sill to head height	bt - Telecoms point
fr - Floor to fill height	s/s - Single power socket
u/s - Underside height	ds/s - Double power socket
ah - Arch head height	ls - Light switch
ap - Arch springing point height	c/p - Cooker point
rad - Radiator	lf - Light fitting
htr - Heater	fl - Fluorescent light fitting
hw - Hot water tank	htr - Intruder alarm sensor
wt - Toilet	fsr - Fire alarm sensor
wb - Wash basin	hazp - Burglar alarm control panel
shr - Shower	facp - Fire alarm control panel
bat - Bath	cp - Control panel
ur - Urinal	w/m - Water meter
hd - Hand dryer	sets - Water stop tap
wp - Waste pipe	ic - Inspection chamber
vp - Vent pipe	m/c - Manhole cover
rwp - Rainwater pipe	cl - Cover level
wf - Water fountain	il - Invert level
g - Gully	Ø - Pipe diameter
c - Concrete	conc - Concrete
h - Roof hatch	bk - Brick
vac - Suspended ceiling	qt - Quarry tiles
h - Room height	v - Vinyl flooring
carp - Carpet flooring	carp - Carpet flooring
b/st - Brick setts	b/st - Brick setts
fb - Floorboards	

Company Information:



22 Duke of York Avenue
Royal Leamington Spa
CV33 9WH
M: 07908 584371
E: admin@bayabc.co.uk
www.bayabc.co.uk

Client Information:

-

Location Address:

Units 11 and 12 Albone Way
Biggleswade
Bedfordshire
SG18 8BN

Drawing Reference:

Ground Floor Plan

Job Reference No:	DWG No:		
CC RS34	001		
Scale:	Date:	Drawn:	Checked By:
A0@1:100	09/05/25	RS	SC