


PLAN AS EXISTING

EXISTING FIRE SAFETY EQUIPMENT

-  CALL POINT
-  SOUNDER
-  SMOKE DETECTOR
-  EMERGENCY LIGHT
-  EMERGENCY EXIT LIGHT
-  FIRE CONTROL PANEL
-  HEAT DETECTOR

ELECTRICAL EQUIPMENT KEY


- | | |
|---|---|
|  | 13A double switch socket outlet at 450mm from ffl |
|  | Single wall switch at 1200mm above ffl |
|  | Double wall switch at 1200mm above ffl |
|  | Triple wall switch at 1200mm above ffl |
|  | Quadruple wall switch at 1200mm above ffl |
|  | Consumer unit |
|  | Air Conditioning Unit |

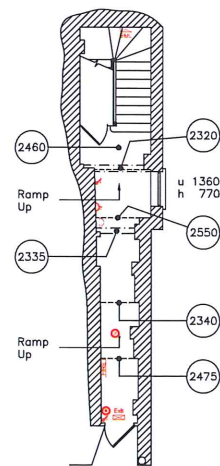

Ground Floor Plan



First Floor Plan

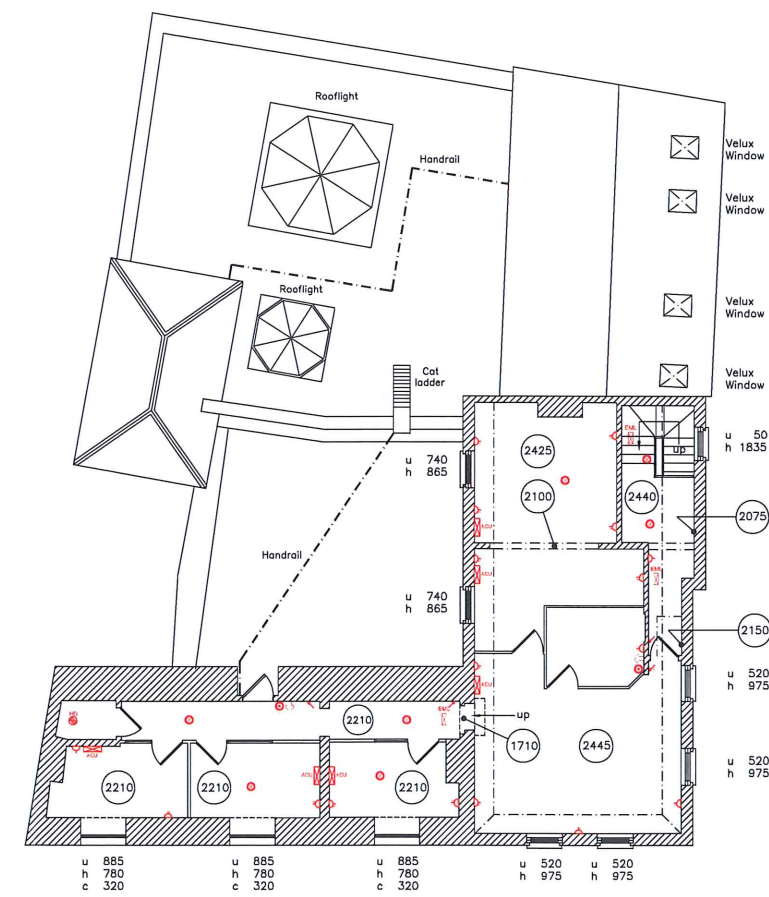

Second Floor Plan

[illegible]

PROJECT
55 - 56 ST MARYS BUTTS
READING
BERKSHIRE

CLIENT
HAMILTON STUBBER (1960) SETTLEMENT

TITLE

**SURVEY INCLUDING FIRE DETECTION EQUIPMENT AND
FIXED ELECTRICAL SWITCHES AND SOCKET OUTLETS**

Boulter Mossman
CHARTERED SURVEYORS

SUITE 1, FESTIVAL HALL HEATH ROAD, PETERSFIELD HAMPSHIRE GU31 4DZ TEL 01730 266722 FAX 01730 265805	PROJECT NO. 3445 DRAWN LW/GG	DRAWING NO. 02 DATE JULY 07	REVISION SCALE 1:100 AT A1
---	---	--	---

PLEASE DO NOT SCALE FROM DRAWING (EXCEPT FOR PLANNING APPROVAL).
ALL DIMENSIONS TO BE CHECKED ON SITE