


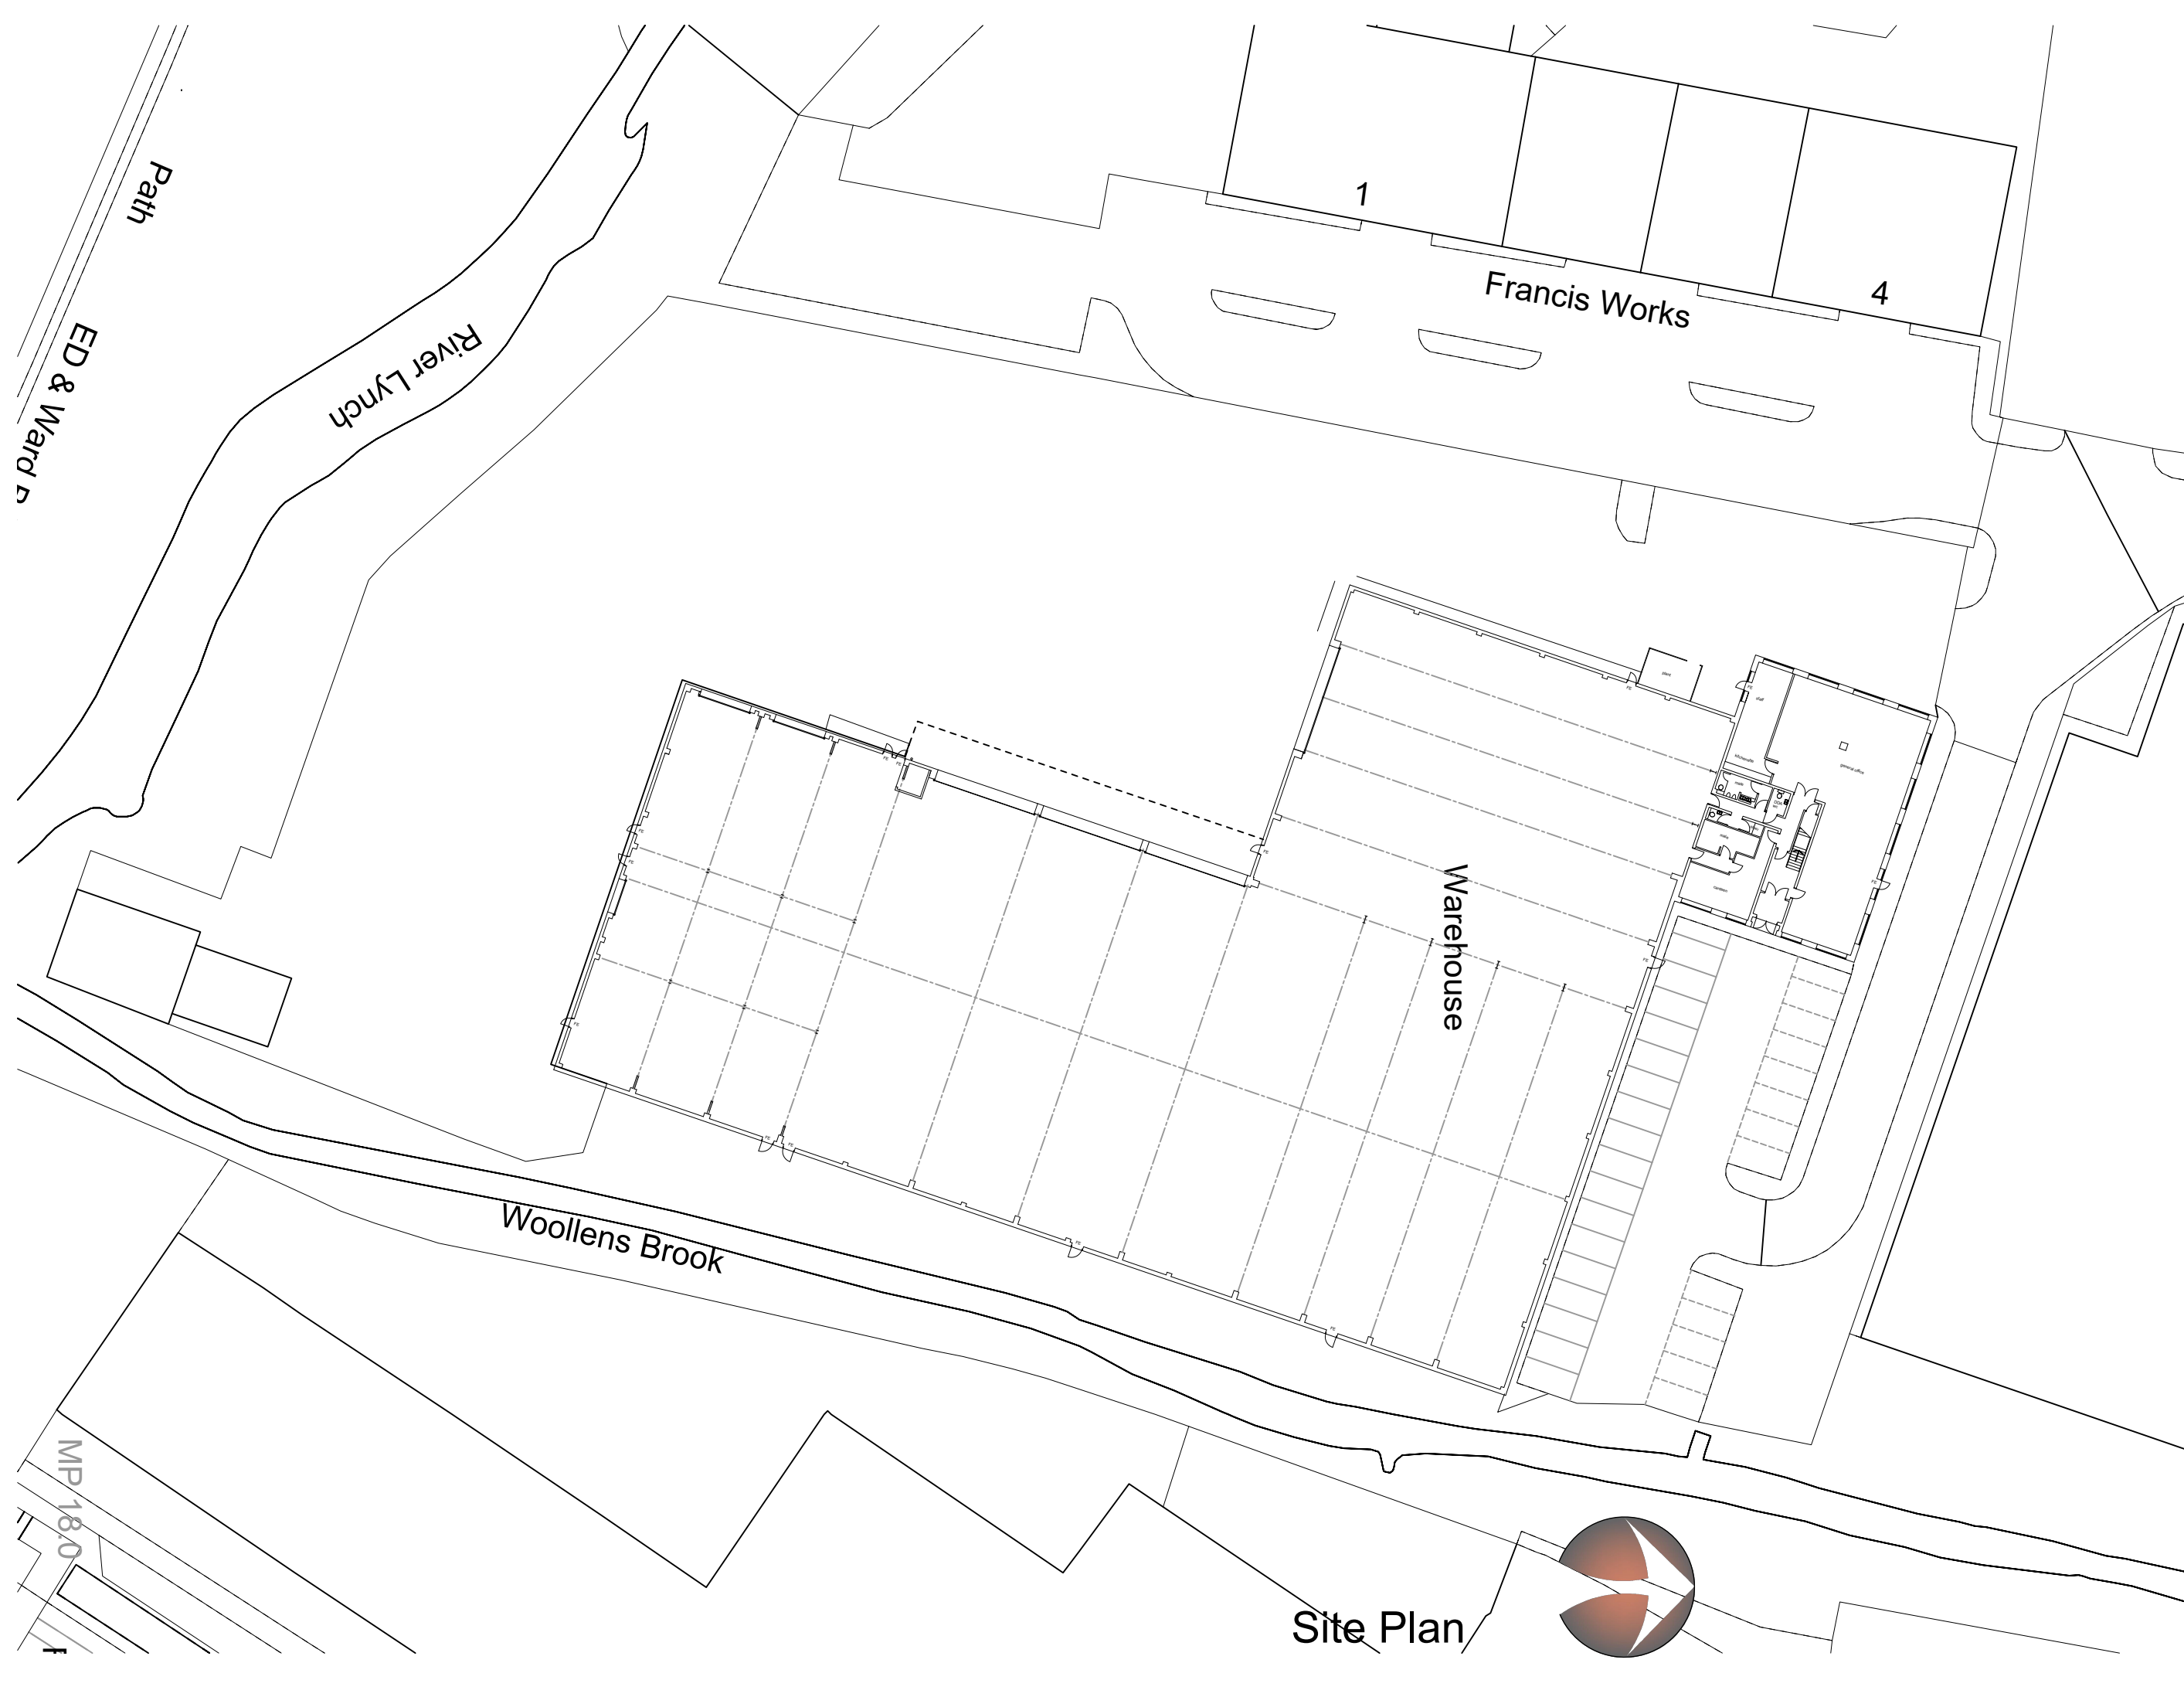

NOTES

1) ALL DIMENSIONS TO BE CHECKED ON SITE AND NOT SCALED FROM THIS DRAWING

2) AIR SHALL BE INFORMED IN WRITING OF ANY DISCREPANCIES

3) ALL DIMENSIONS ARE IN METRES ONLY

4) THE ORIGIN AND ORIENTATION OF THE SURVEY GRID RELATE TO AN ARBITRARY GRID

5) ALL LEVELS ARE BASED ON AN ARBITRARY DATUM.

GENERAL ARRANGEMENT

A	Alarm	RS	Illuminated Road Sign
AC	Air Conditioner	RJ	Junction Box
AD	Air Arch Height	KO	Ko Outlet
AL	Airch Level	L	Lift
ALH	Airch Spring Height	LB	Lift Box
ASL	Arch Spring Level	LP	Lift Post
ATM	Automated Telling Machine	M	Manhole
B	Bulbhead	ML	Multiple
BB	Battled Base	MU	Manhole
BGP	Break Glass Point	MS	Minimum
BB	Base to Beam height	M	Marker
B	Borehole	NB	Noise Board
BS	Base	NS	None Pass
B/S	Block Steps	OH	Overhead
BSP	Block Retaining Wall	OSB	Onion Branded Form
BSL	Beam Soffit Level	P	Post
BS	Base to Top	PL	Plaster Light
BW	Black Wall	PGM	Permanent Ground Mark
BWF	Black Wall Face	PM	Permanent Light
CB	Close Boarded Fence	PF	Painting Mark
CCFV	Close Circuit Television	PRF	Post and Rail Fence
CH	Ch to Head Height	PS	Painting Blows
CH	Chimney	PRF	Post and Rail Fence
CF	Compacted Joint Fence	RS	Rail
CL	Core Level	RMS	Recessed Door Mat
CLF	Chain Link Fence	RL	Riding Line
CO	Column	RG	Road Gully
CO	Concrete	RL	Ridge Level
CS	Cable in Wall	RS	Road Sign
CPS	Concrete Paving Slabs	RS	Road Sign
CTV	Cable Television Box	RS	Road Sign
CP	Cupboard	RSP	Road Sign Post
C	Depth	RSP	Road Sign Post
DC	Duct Cover	SB	Sign Board
DB	Duct Box	SB	Sign Board
DP	Down Pipe	SC	Sign Board
DC	Ducting Channel	SB	Sign Board
DB	Duct Box	SB	Sign Board
EC	Electrical Inspection Cover	SB	Sign Board
ESR	Electricity Supply Box	SL	Sign Light
EL	Eave Level	SL	Sign Light
EM	Electricity Meter	SP	Sign Post
EP	Electricity Pole	SP	Sign Post
ER	Earthing Rod	SS	Security Screen
ESD	Electricity Switchgear	T	Telephone
FA	Fire Alarm	Tac	Tactile Paving
FB	Fire Box	TBM	Temporary Bench Mark
FC	Fire to C to Height	TCB	Telephone Call Box
FE	Fire Extinguisher	TCD	Telephone Control Box
FI	Fire Hydrant	TCS	Telephone Control Box
FIR	Fire Risk Road	TL	Traffic Light
FL	Fire	TL	Traffic Light
FR	Footlight	TLB	Traffic Light Control Box
G	Grp	TLB	Traffic Light Control Box
G	Gully	TOP	Top of Wall
G	Grp	TOP	Top of Wall
GM	Gas Cock	TP	Telephone Pole
GP	Gas Pipe	Typ	Type
GV	Gas Valve	UL	Under to L to B
h	Height	V	Vent
H	Head Beam	V	Vent
HR	Handrail	W	Window
IB	Interlocked Barrier	WCL	Window C/L Level
IC	Inspection Cover	WH	Water Head Level
ICN	Traffic Light Inspection Cover	WI	Water Inspection Cover
IL	Inset Level	WM	Water Meter
IRP	Iron Railing Fence	WV	Water Valve

SYMBOLS

	Floor to Soffit Height
	Floor to False Ceiling Height
	Soffit Level
	False Ceiling Level
	Stair Arrows (points up)
	Structural Overhead Slope (points up)
	Non-Structural Overhead Slope (points up)
	Roof Slope (points down)
	Structural Ceiling Vault/Half Vault
	Non-Structural Ceiling Vault/Half Vault

REVISIONS

REV.	DATE	AMENDMENTS	INITIAL
PRELIMINARY		TENDER	CONSTRUCTION
SKETCH		MEASURED SURVEY	CONTRACT

TITLE

SITE PLAN

Air Building Consultancy Limited

85 Great Portland Street

First Floor. London. W1W 7LT

020 3834 7906

www.air.co.uk

PROJECT NAME

H28 GEDDINGS ROAD

HODDESDON

EN11 0NT

DATE

10.2024

DRAWN BY

IW

SCALE

1:500 @A3

CHECKED

KS

DRAWING NUMBER

003

REVISION
