


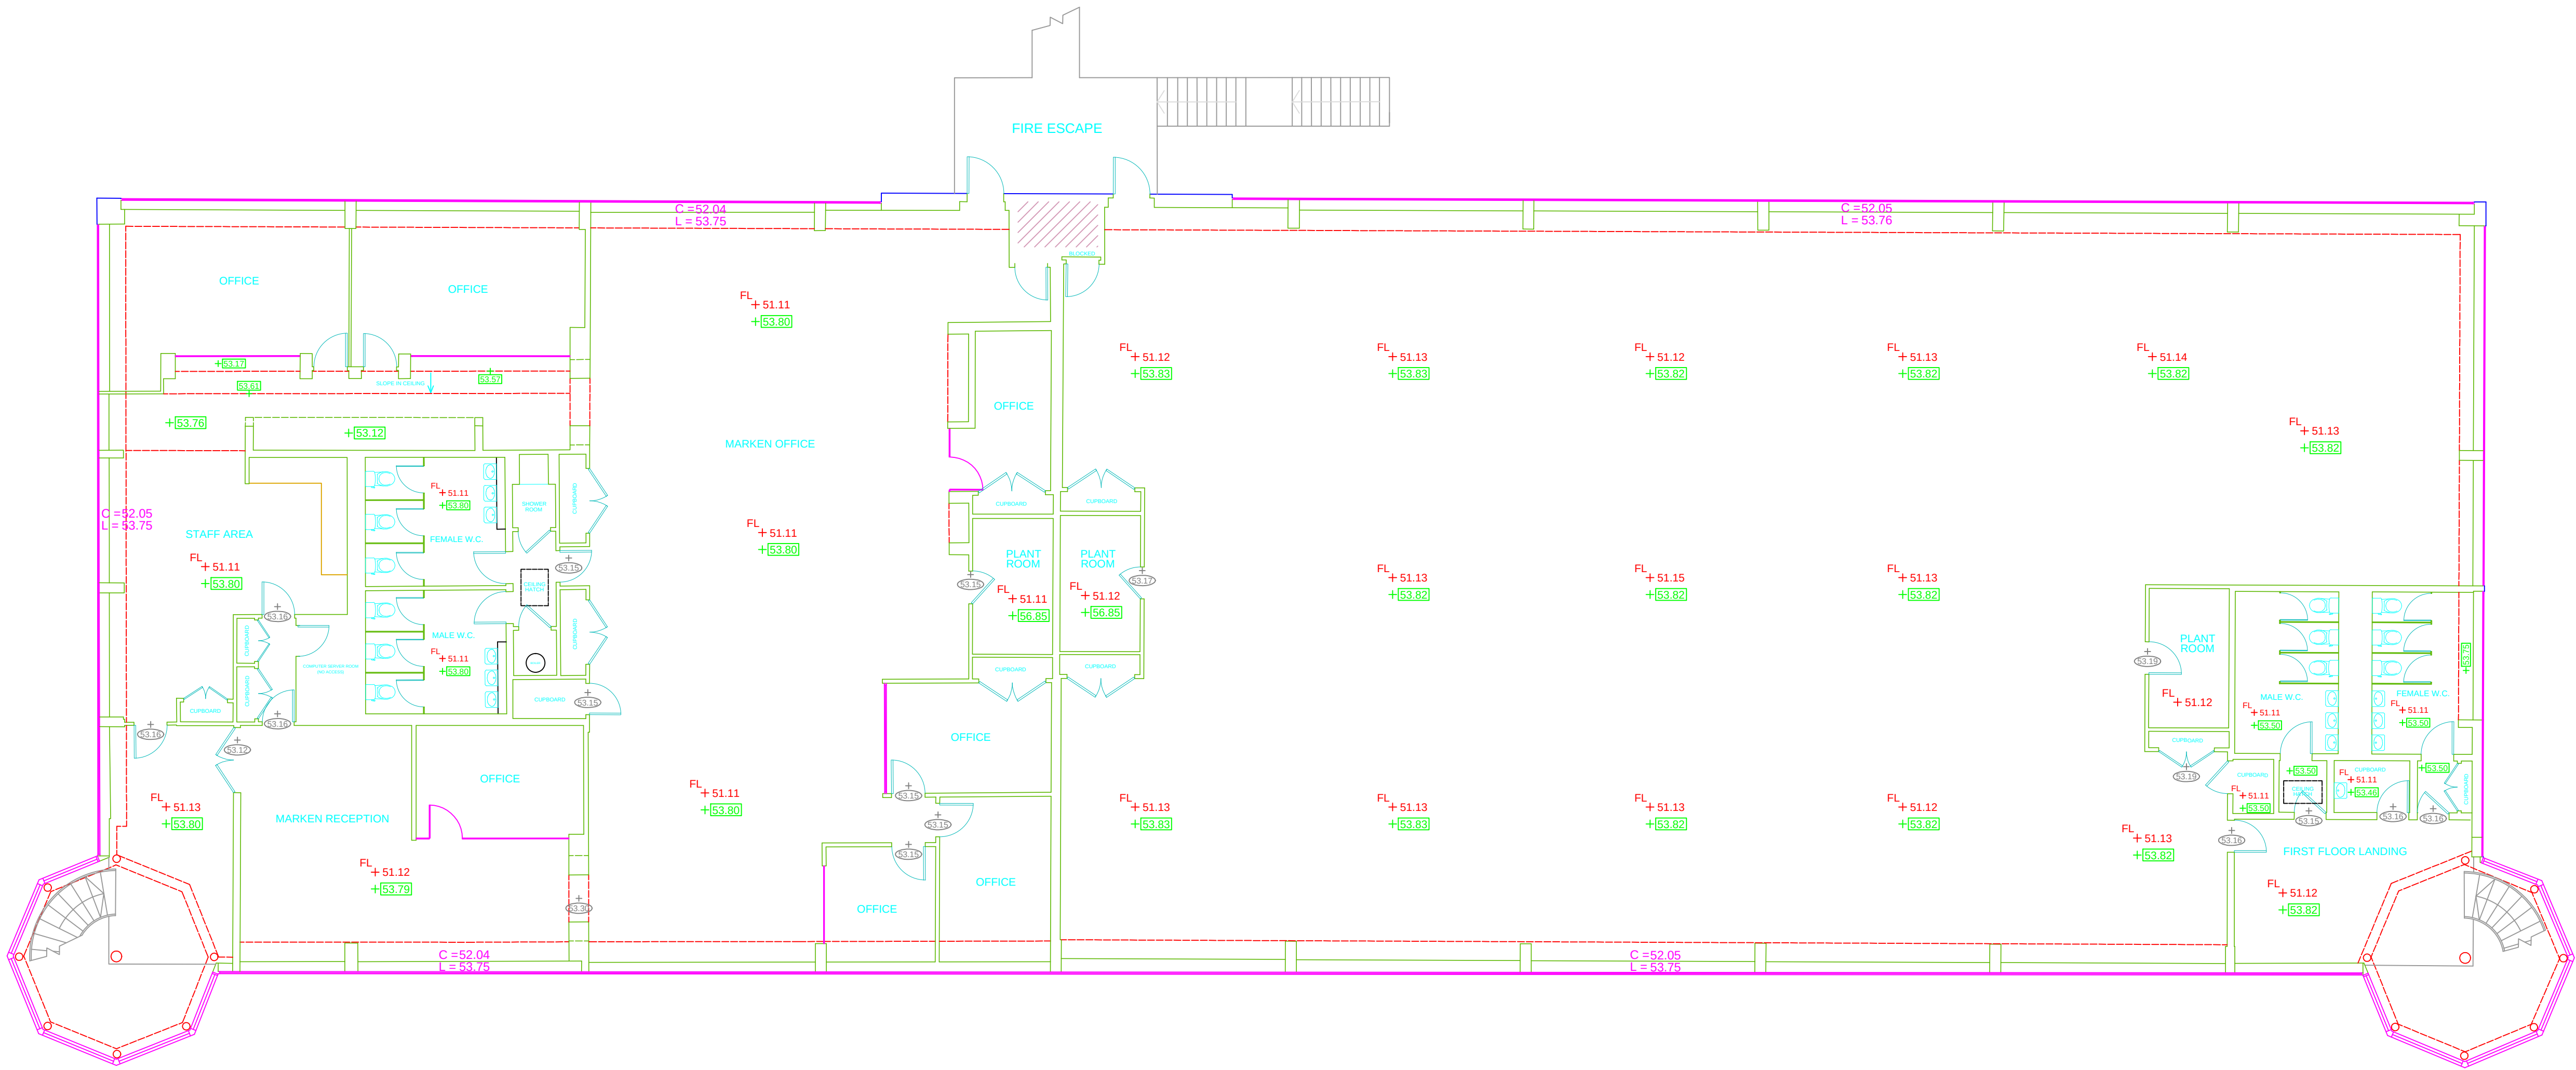

FIRST FLOOR

NOTES

a)

All survey levels are related to OS Datum.
(National GPS Network).

b)

Whilst G.L. Surveys has made every effort to locate all topographical and building features we cannot accept responsibility for any features which may be omitted if they are obscured from view for any fixed or temporary reason at the time of the survey taking place.

LEGEND

AV - Air Valve
BH - Borehole
B - Bollard
BT - British Telecom Cover
C - Cover(unknown service)
CL - Cill Level
COL - Column
CT - Cable Telecom Cover
D - Drain
DK - Drop Kerb
EC - Electricity Cover
EL - Eaves Level
EP - Electricity Pole
ER - Earth Rod
FH - Fire Hydrant
FL - Floor Level
G - Gully
GAS - Gas Cover
GPO - Post Office Box
GT - Gas Tally
IC - Inspection Cover
IL - Invert Level
KL - Keep Left Bollard
LB - Lighting Bollard
LL - Lintel Level
LP - Lamp Post
LT - Lighting Tower

MC - Mercury Cover
MH - Manhole
MKR - Marker
MP - Mooring Post
MR - Mooring Ring
OBM - O.S. Benchmark
OHW - Overhead Wires
OTP - O.S. Ttg Point
P - Post
PM - Parking Meter
PVLN - Elec. Pylon
RE - Roading Eye
RL - Ridge Level
RS - Road Sign
SP - Sign Post
SV - Sluice Valve
T - Tolly
TPPT - Trial Pit
TL - Traffic Lights
TP - Telegraph Pole
TV - Cable T.V. Cover
VP - Vent Pipe
WC - Water Cover
WH - Wall Head Level
WL - Water Level
WM - Water Meter
WT - Water Tolly



G.L.SURVEYS

87 COMELY BANK AVENUE
EDINBURGH EH4 1EU
0131 315 2012
edinburgh@glssurveys.com

CLIENT

HURSTWOOD HOLDINGS

JOB TITLE

ALEXANDRA HOUSE
21 CLIFTONHALL ROAD
NEWBRIDGE

DRAWING TITLE

FIRST FLOOR PLAN

DATE	DECEMBER 2018	SCALE	1:100@A1
SURVEYED BY	AR	EDITED BY	AR
CHECKED BY			
JOB NUMBER:	18-11-09	DRAWING NUMBER:	02