


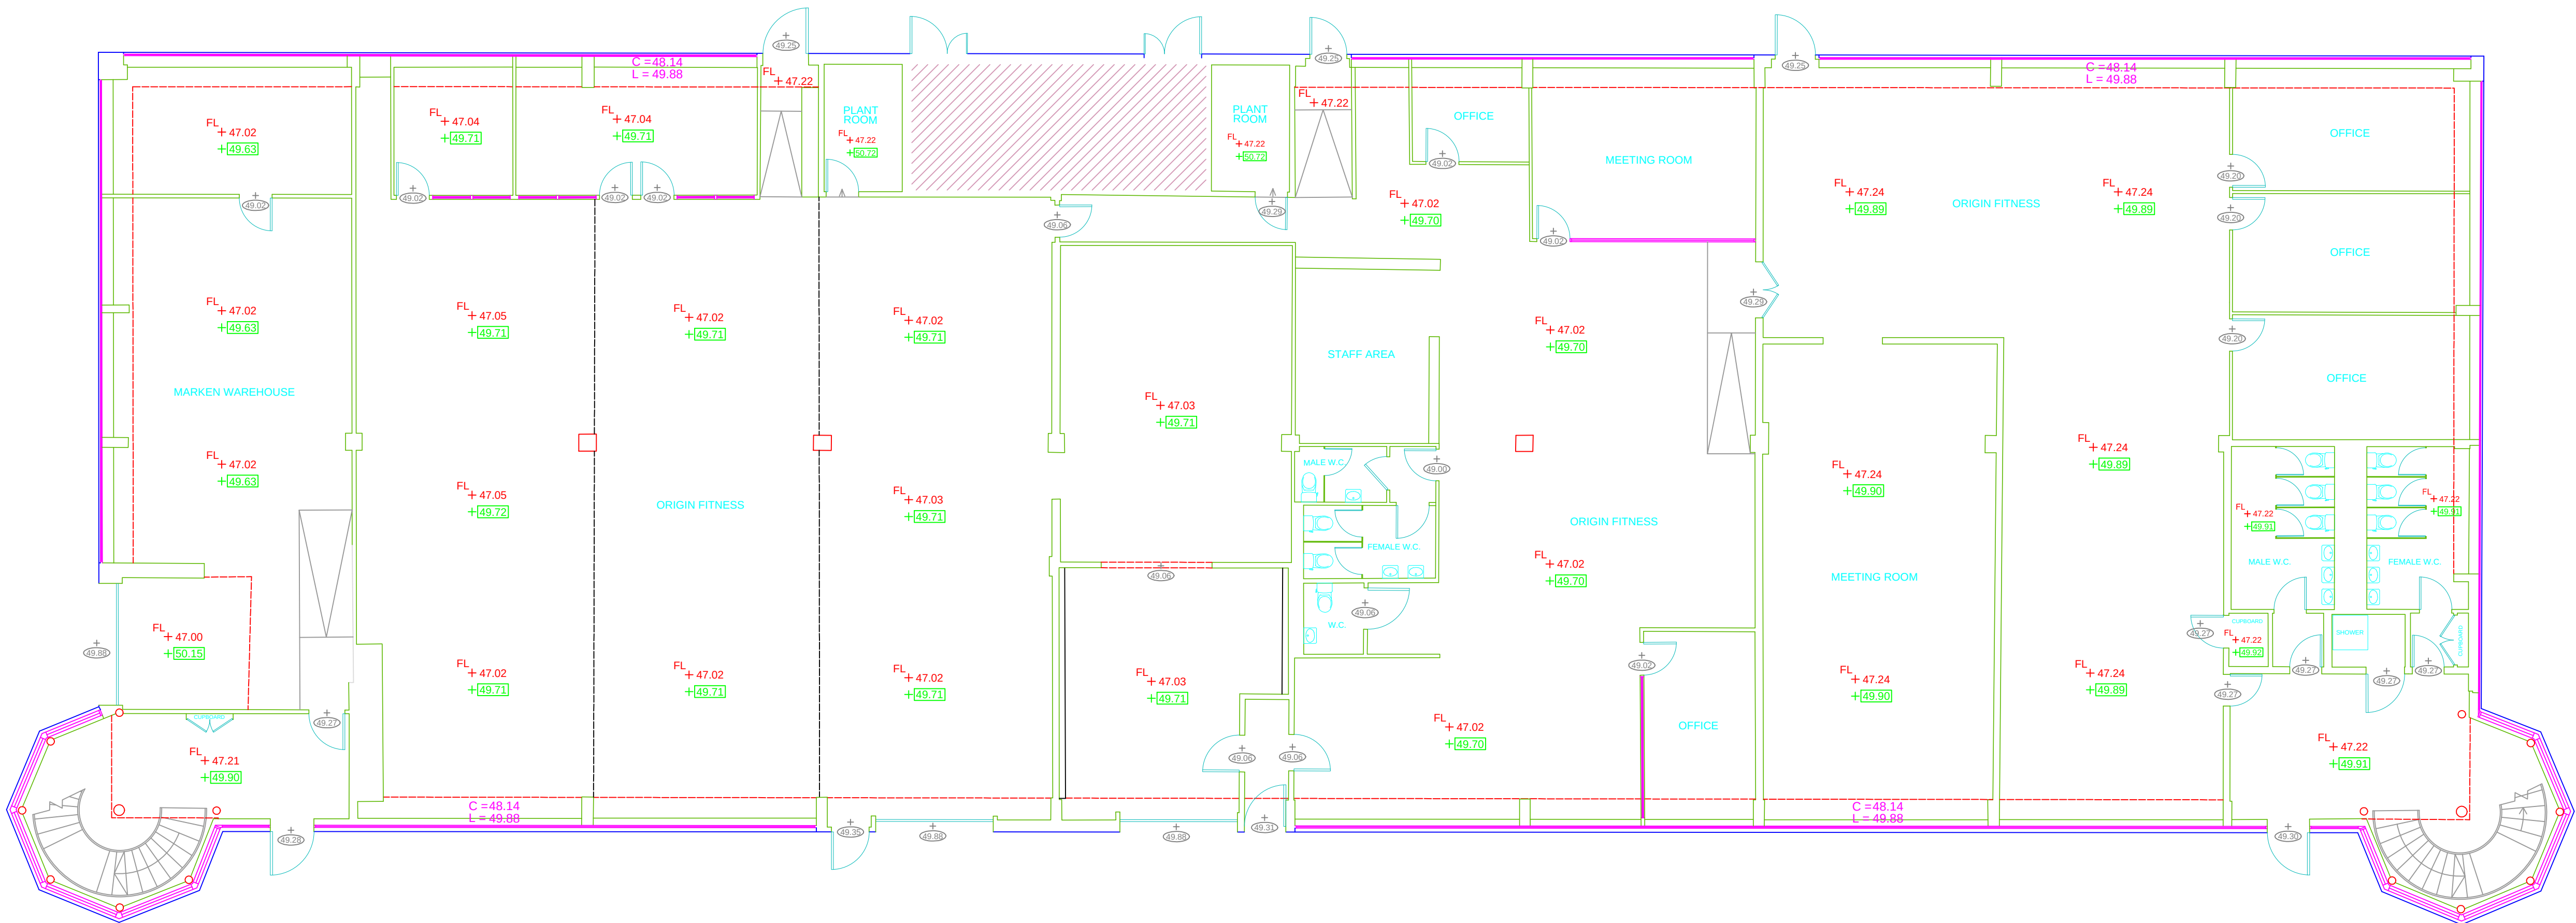

GROUND FLOOR

NOTES

i)

All survey levels are related to OS Datum.
(National GPS Network).

ii)

Whilst G.L.Surveys has made every effort to locate all topographical and building features we cannot accept responsibility for any features which may be omitted if they are obscured from view for any fixed or temporary reason at the time of the survey taking place.

LEGEND

AV - Air Valve

BH - Borehole

B - Bollard

BT - British Telecom Cover

C - Cover(unknown service)

CL - Cill Level

COL - Column

CT - Cable Telecom Cover

D - Drain

DK - Drop Kerb

EC - Electricity Cover

EL - Eaves Level

EP - Electricity Pole

ER - Earth Rod

FH - Fire Hydrant

FL - Floor Level

G - Gully

GAS - Gas Cover

GPO - Post Office Box

GT - Gas Tally

IC - Inspection Cover

IL - Invert Level

KL - Keep Left Bollard

LB - Lighting Bollard

LL - Lintel Level

LP - Lamp Post

LT - Lighting Tower

MC - Mercury Cover

MH - Manhole

MKR - Marker

MP - Mooring Post

MR - Mooring Ring

OBM - O.S. Benchmark

OHW - Overhead Wires

OTP - O.S. Ttg Point

P - Post

PM - Parking Meter

PVLN - Elec. Pylon

RE - Roading Eye

RL - Ridge Level

RS - Road Sign

SP - Sign Post

SV - Sluice Valve

T - Tolly

TPPT - Trail Pt

TL - Traffic Lights

TP - Telegraph Pole

TV - Cable T.V. Cover

VP - Vent Pipe

WC - Water Cover

WH - Wall Head Level

WL - Water Level

WM - Water Meter

WT - Water Tolly



G.L.SURVEYS

87 COMELY BANK AVENUE
EDINBURGH EH4 1EU
0131 315 2012
edinburgh@glssurveys.com

CLIENT

HURSTWOOD HOLDINGS

JOB TITLE

ALEXANDRA HOUSE
21 CLIFTONHALL ROAD
NEWBRIDGE

DRAWING TITLE

GROUND FLOOR PLAN

DATE

DECEMBER 2018

SCALE

1:100@A1

SURVEYED BY

AR

EDITED BY

AR

CHECKED BY

JOB NUMBER:

18-11-09

DRAWING NUMBER:

01